



| | | | |
|------------|----------|----------------|-------|
| Issue Date | 3/8/2012 | Project Number | 12003 |
| Revisions | | | |

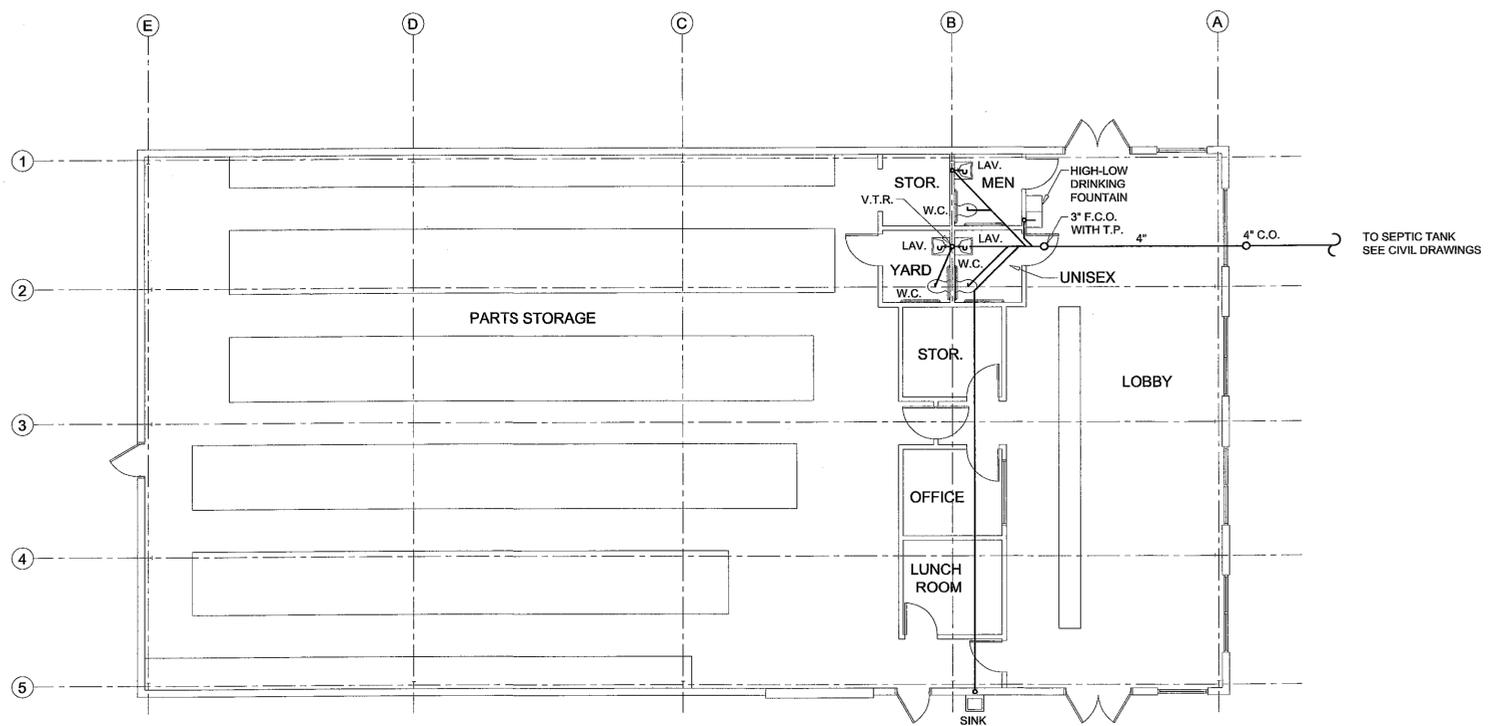

1 PLUMBING PLAN
P2.1 SCALE: 1/8" = 1'-0"

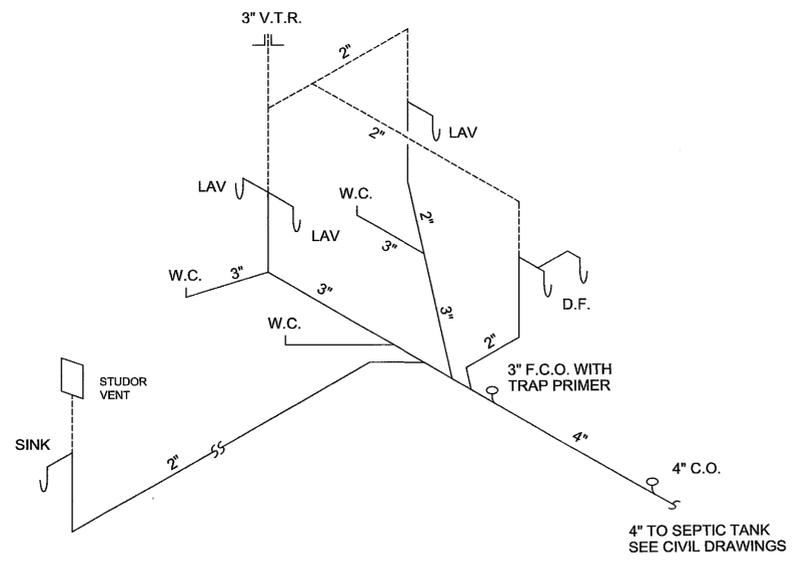

2 SANITARY RISER DIAGRAM
P2.2 NOT TO SCALE

POWER RECEIVED
JUN 19 2012